

THESE DRAWINGS ARE NOT TO BE USED OR MEASURED WITH A SCALE TO LIMITED ACCURACY. THESE DRAWINGS ARE NOT TO BE USED OR MEASURED WITH A SCALE TO LIMITED ACCURACY. THESE DRAWINGS ARE NOT TO BE USED OR MEASURED WITH A SCALE TO LIMITED ACCURACY.

NOTES:

- ROOF MATERIALS SHOULD BE LIGHT-COLORED ALBETO OR A PLANTED SURFACE AND SHALL COMPLY WITH ALL APPLICABLE SECTIONS OF MIAMI 21 CODE.

POOL SAFETY BARRIER NOTES:


- POOL SAFETY BARRIER IS PROVIDED BY WALLS OF ELEVATOR LOBBY.
- DOORS FROM ELEVATOR LOBBY WILL BE EQUIPPED WITH A SELF-LATCHING, SELF-CLOSING DEVICE AND SHALL BE OPERATED BY A KEY LOCK, ELECTRONIC CARD ACCESS OPENER, OR INTEGRAL COMBINATION LOCK. THE OPERABLE PARTS OF SUCH LOCKS/OPENERS SHALL BE INSTALLED AT 54" MINIMUM ABOVE THE FINISH FLOOR WHICH IS APPROVED BY THE AUTHORITY HAVING JURISDICTION.
- DOORS FROM STAIRS WILL BE USED AS EXIT ONLY AND SHALL BE LOCKED AGAINST RE-ENTRY FROM INSIDE THE STAIR, TYP. RE-ENTRY FOR THE STAIR WILL OCCUR ONE LEVEL BELOW AT LEVEL 5.

NOTE

NO NIGHTTIME SWIMMING ACTIVITIES WILL BE ALLOWED.

ELECTRIC GRILL / GAS GRILLS:

- ALL ELECTRICAL GRILLS AND GAS GRILLS WILL BE PROVIDED WITH AN APPROVED FIRE EXTINGUISHER WITHIN 10 FEET OF ANY GRILL OR OPEN FLAME IN ADDITION TO THE REGULARLY SPACED EXTINGUISHERS IN THE LIFE SAFETY PLAN LAYOUT.
- ALL ELECTRICAL GRILLS AND GAS GRILLS WILL BE TIED TO THE FIRE ALARM AND AUTOMATICALLY TURN OFF IN THE EVENT OF AN ALARM.
- AN EMERGENCY SHUT OFF SWITCH SHALL BE PROVIDED:
 - ONE WITHIN 5 FEET OF EACH RESPECTIVE ELECTRICAL GRILL / GAS GRILL.
 - SHUT OFF SHALL BE IDENTIFIED BY SIGN. THE SIGN SHALL BE WITH A RED BACKGROUND WITH WHITE LETTERS TO READ "EMERGENCY SHUT OFF FOR GRILL". LETTERING IS TO BE A MINIMUM OF 2" IN HEIGHT WITH 3/16" BRUSH STROKE WIDTH FOR THE LETTERING.
- ALL ELECTRICAL GRILLS AND GAS GRILLS ARE TO BE PROVIDED WITH A UL LISTING FOR ITS INTENDED USE.
 - ALL ELECTRIC GRILLS AND GAS GRILLS SHALL BE PERMANENTLY INSTALLED IN PLACE.
 - GAS GRILLS SHALL BE INSTALLED USING PIPING THAT IS UL LISTED FOR ITS INTENDED USE AND BE INSPECTED BY PLUMBING.
 - ALL ELECTRIC GRILLS AND GAS GRILLS SHALL BE 20' AWAY FROM ANY STRUCTURE.
- A THIRTY (30) MINUTES TIME OUT SHALL BE PROVIDED TO SHUT OFF GRILL.
- THE FLOOR AREA OF THE GRILLS WILL BE A NON-COMBUSTIBLE SURFACE AROUND THE PERIMETER OF THE GRILL BY 10'.
- SPRINKLER COVERAGE IS PROVIDED, SEE MEP DRAWINGS.

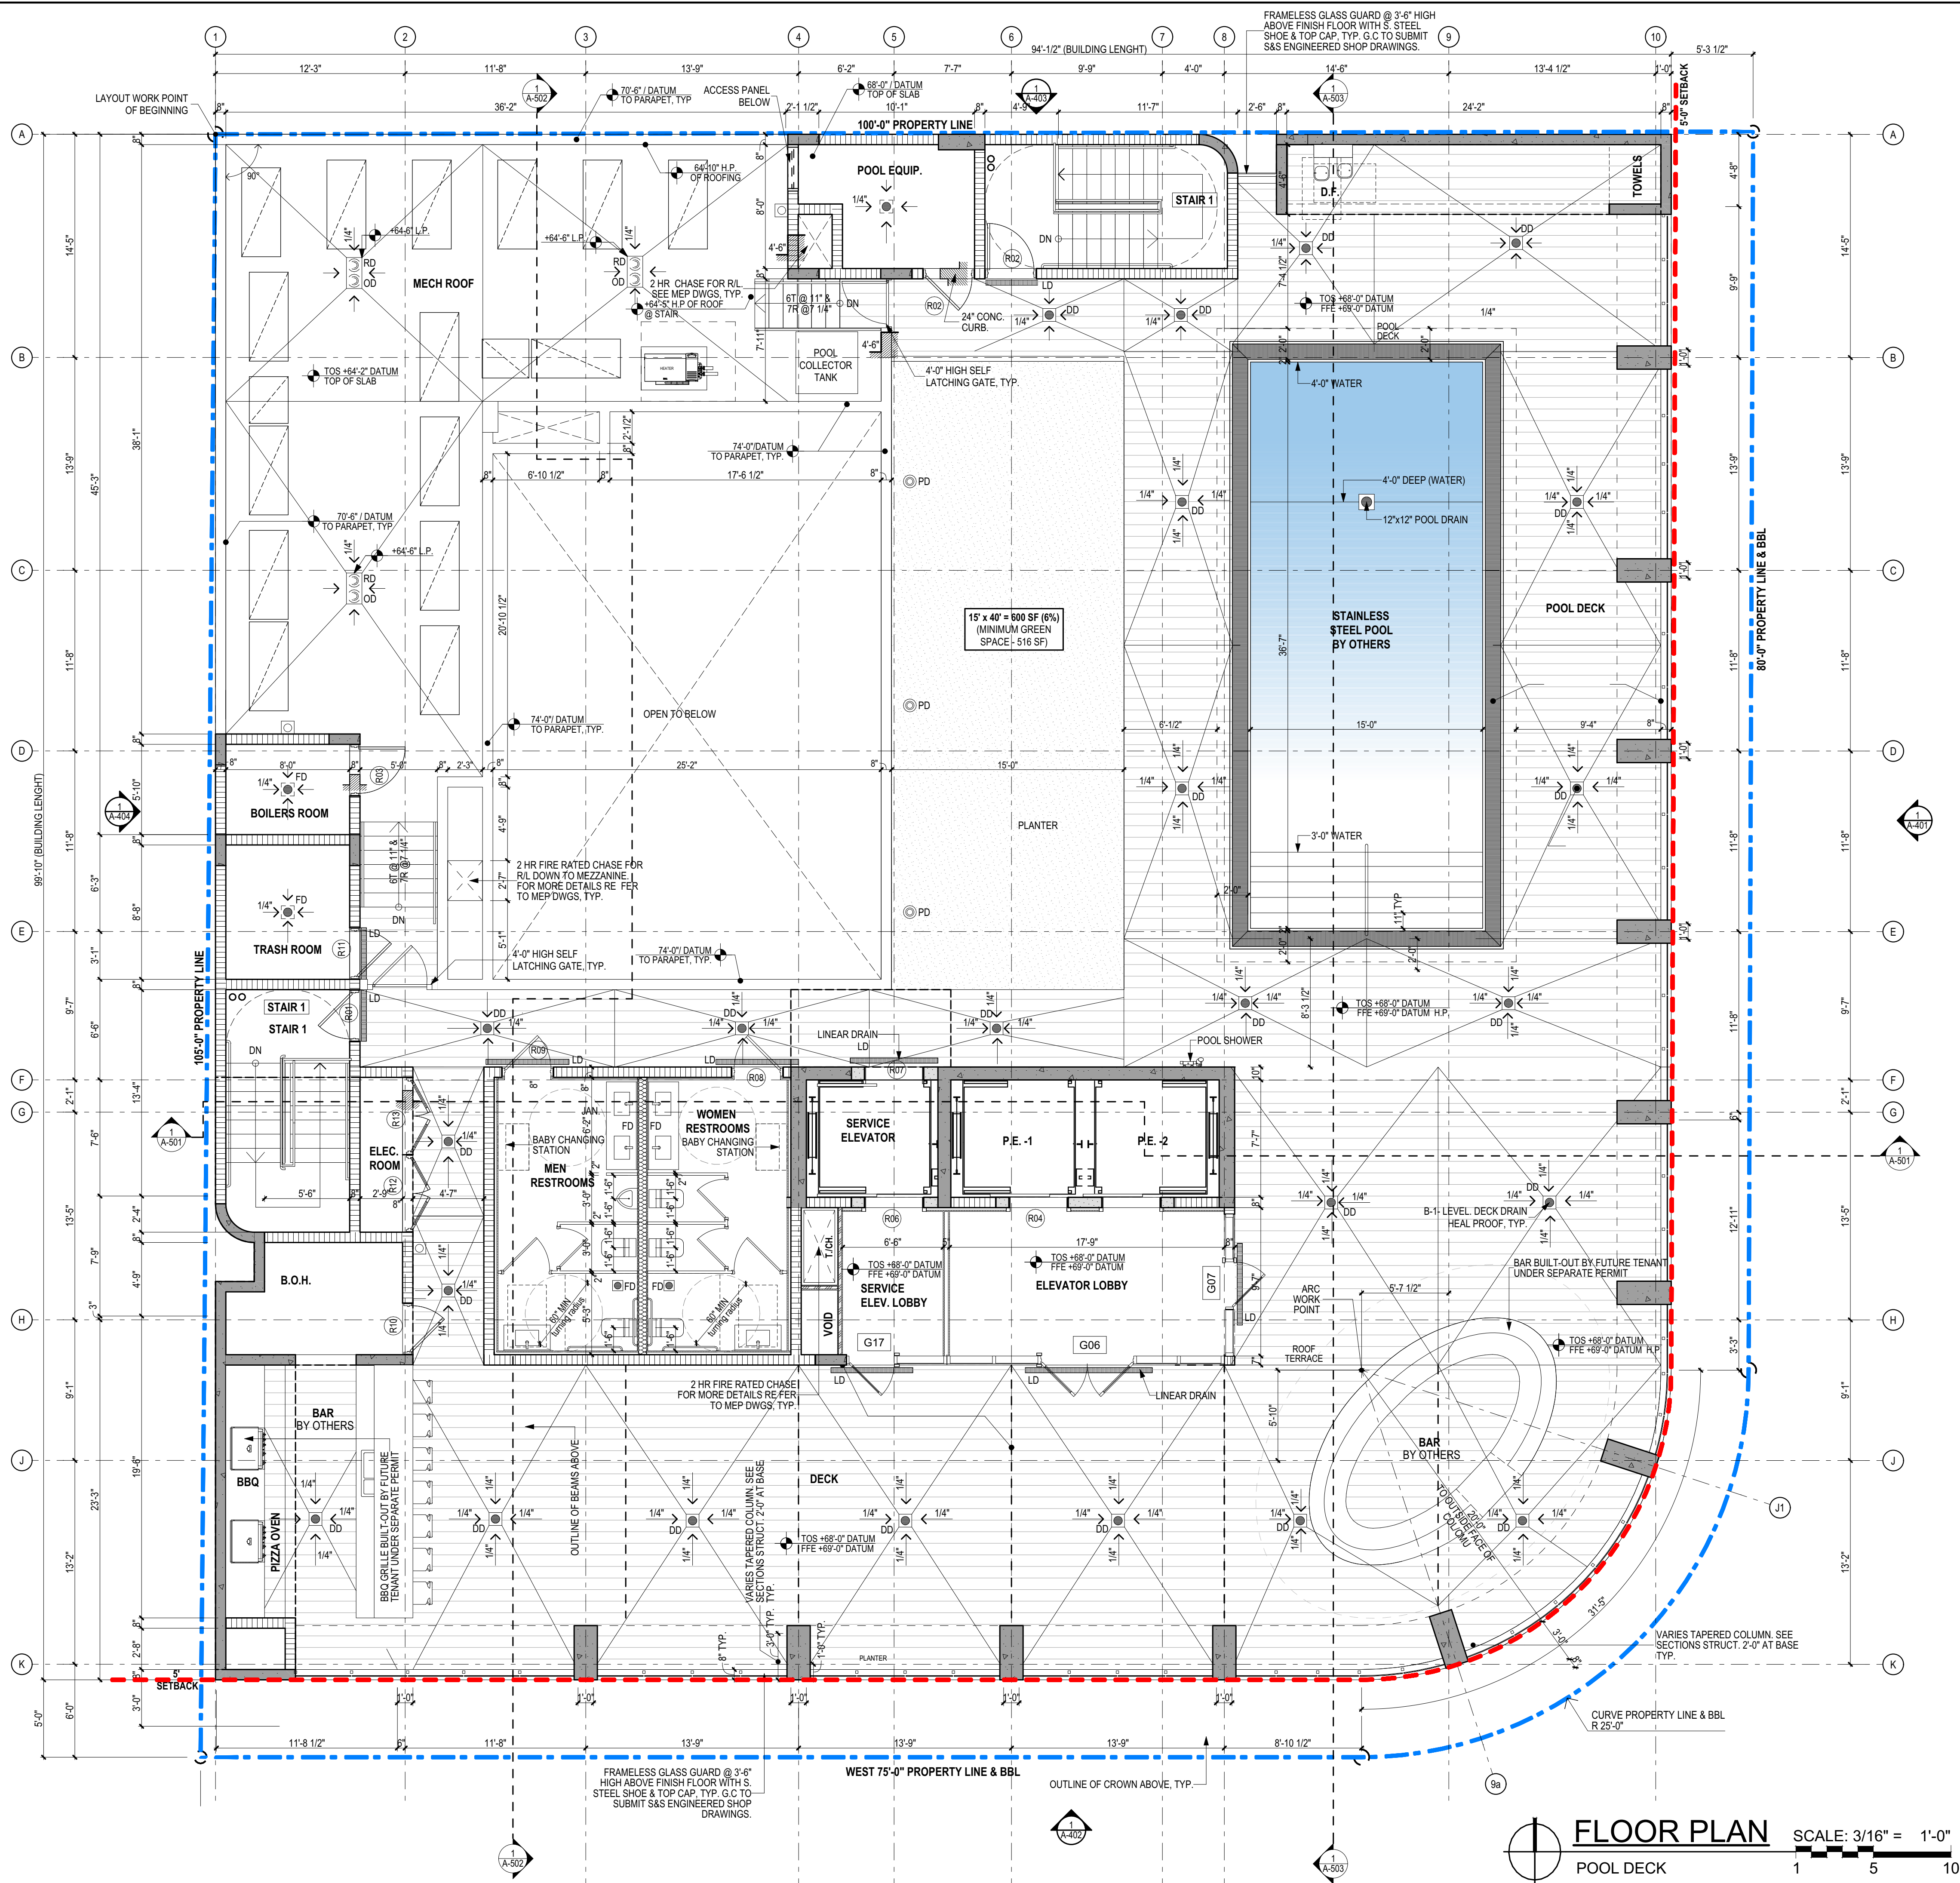

FLOOR PLAN
POOL DECK
SCALE: 3/16" = 1'-0"

ALAIN R. BARTROLI
architect, inc.

3400 Coral Way, Suite 602
Miami, FL 33145
t. 786.908.3244
e. arb@alainbartrol.com
w. www.alainbartrol.com

Seal of Project Architect

Alain R. Bartrol, AIA, LEED AP-BD+C
AA26003207 - ARS2820

Consultants

Project Owner
111 WYNWOOD, LLC.
2225 N. Commerce Pkwy.
Ste 4
Weston, FL 33326

111 WYNWOOD - HOTEL
111 NW 26 STREET
WYNWOOD-MIAMI, FLORIDA 33127

Date of Issue:
08/03/2018

Revisions:

NO.	REVISION	DATE
1	OWNER CHANGES	12/04/2018
2	B. COMMENTS	07/21/2019
3	B. COMMENTS	12/10/2019

Submittal Type:
PERMIT SET

Drawn By:
AB

Checked By:
AB

Scale:
AS SHOWN

Job Number:
1604

Sheet Number:
A-106